
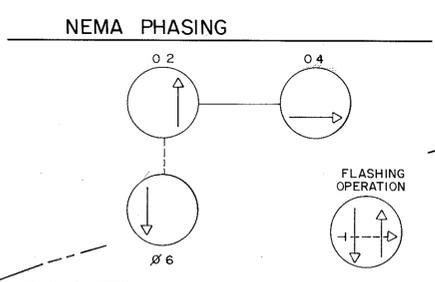
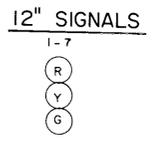
 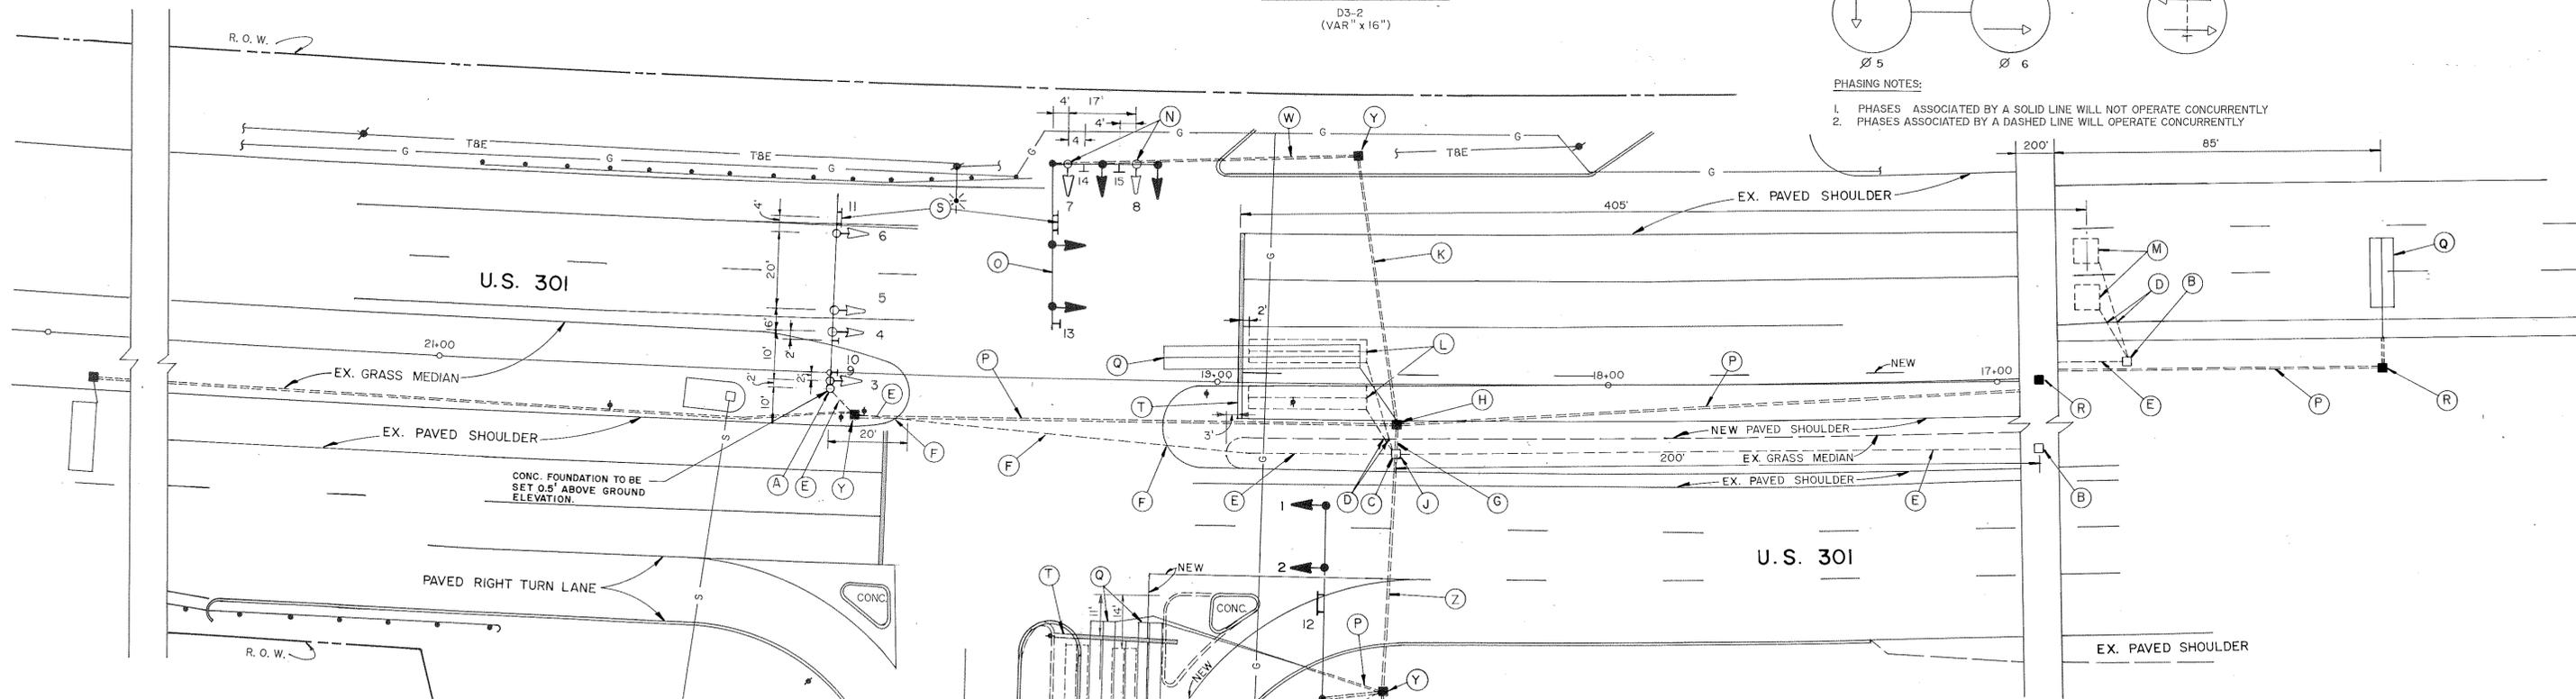

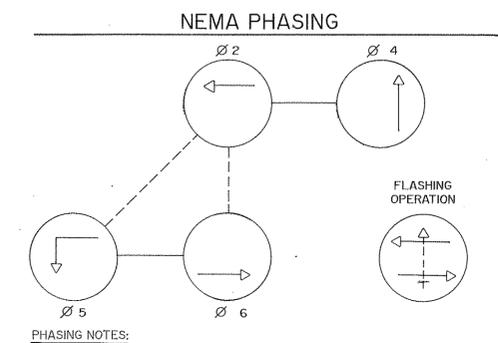
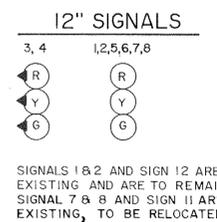


F H WA REGION NO	STATE	FED. AID PROJ. NO	SHEET NO.	TOTAL SHEETS
3	MD.			

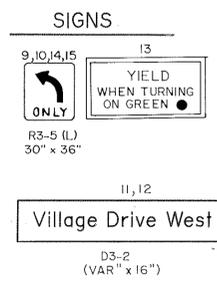

- NOTES - CONSTRUCTION NEAR GAS LINES**
- THE CONTRACTOR SHALL HAND DIG TEST PITS AT ALL GAS CROSSINGS TO DETERMINE THE EXACT LOCATION AND DEPTH WELL IN ADVANCE OF CONSTRUCTION. VERTICLE AS-BUILT INFORMATION ON GAS MAIN DEPTH IS UNAVAILABLE.
 - FOR MARKING LOCATIONS OF WASHINGTON GAS FACILITIES, PLEASE NOTIFY "MISS UTILITY" AT 1 - 800 - 257 - 7777, 48 HOURS PRIOR TO ANY EXCAVATION OR CONSTRUCTION.
 - NOTIFY WASHINGTON GAS, TRANSMISSION DEPARTMENT, (703) 750 - 4205, 48 HOURS PRIOR TO ANY EXCAVATION IN THE VICINITY OF GAS TRANSMISSION LINES.
 - MARYLAND NATIONAL GAS, TRANSMISSION DEPARTMENT (703) 750 - 4205 IS TO BE NOTIFIED IF DAMAGE OCCURS TO ANY GAS LINE.

- NOTES**
- "D.O." INDICATES DELAY OUTPUT LOOP DETECTOR
 - LOOP DETECTORS AND CONDUITS SHALL BE INSTALLED PRIOR TO THE INSTALLATION OF PAVEMENT MARKING.
 - PAVEMENT MARKINGS ARE TO BE INSTALLED BY THE CONTRACTOR IN ACCORDANCE WITH S.H.A. STANDARDS.
 - THIS IS A REVISION TO THE EXISTING CONTRACT THAT WAS INSTALLED.
 - SIGNAL CONTRACTOR SHALL COORDINATE ACTIVITIES WITH THE PAVEMENT CONTRACTOR
 - SIGNAL CONTRACTOR IS TO INSTALL PAVEMENT MARKINGS. SEE PAVING AND GRADING PLAN FOR LOCATION OF PAVEMENT MARKINGS.

GEOMETRICS LEGEND

EXISTING _____
PROPOSED - - - - -
RIGHT OF WAY LINE - - - - -

LEGEND OF UNDERGROUND AND OVERHEAD UTILITIES

GAS — G — G —
SEWER — S — S —
WATER — W — W —
ELECTRIC — E — E —
CABLE TV — TV — TV —
TELEPHONE — T — T —
AERIAL CABLE — A — A —

LUKAS Associates
Transportation Planning & Engineering Consultants
451 Hungerford Dr., Rockville, MD. 20850
Tel. (301) 340-9166

REVISIONS	APPROVALS
(A) MODIFY SIGNAL 8 INSTALL NEW SIGNAL FOR NEW GEOMETRICS 12/90	ORIGINAL ON FILE
AAL [Signature]	CHIEF, DESIGN SECTION
	ASST. DISTRICT ENGINEER, TRAFFIC
	CHIEF, BUREAU OF TRAFFIC ENGINEERING
	DEPUTY CHIEF ENGINEER, OFFICE OF TRAFFIC

MARYLAND DEPARTMENT OF TRANSPORTATION
STATE HIGHWAY ADMINISTRATION - OFFICE OF TRAFFIC
BUREAU OF TRAFFIC ENGINEERING

S H A CONTRACT NO. 855-16087

US 301 AND VILLAGE DR. WEST
COUNTY: PRINCE GEORGE'S

DRAWN BY: H. KILIAN
DES. BY: M. A. JOHNSON
CHK. BY: _____

DATE: 7-7-77
SCALE: 1" = 20'

F.A.P. NO. _____
S.H.A. NO. P-509-501-385

TS/FILE NO. 1521 A
SHEET NO. 6 OF 6

16030116.07